Village of Dobbs Ferry New York

Gould Park Improvements 2023


ADDENDUM NO. 3 September 8, 2023

The following revisions are being issued to the Contract Specifications and Drawings for the above referenced Project.

1) See attached Sheet E-101: Electrical Site Plan, the Luminaire schedule previously stated, "Provided and installed by Musco." However, the lighting fixtures, poles and related equipment shall be provided and installed by the contractor.

The contractor shall sign for the receipt of addendum in Section C, page C-4.

THIS ADDENDUM MUST BE SUBMITTED TOGETHER WITH THE ORIGINAL SPECIFICATIONS AND CONTRACT DOCUMENTS BOOK. SUBMIT THIS ADDENDUM IN ITS ENTIRETY.

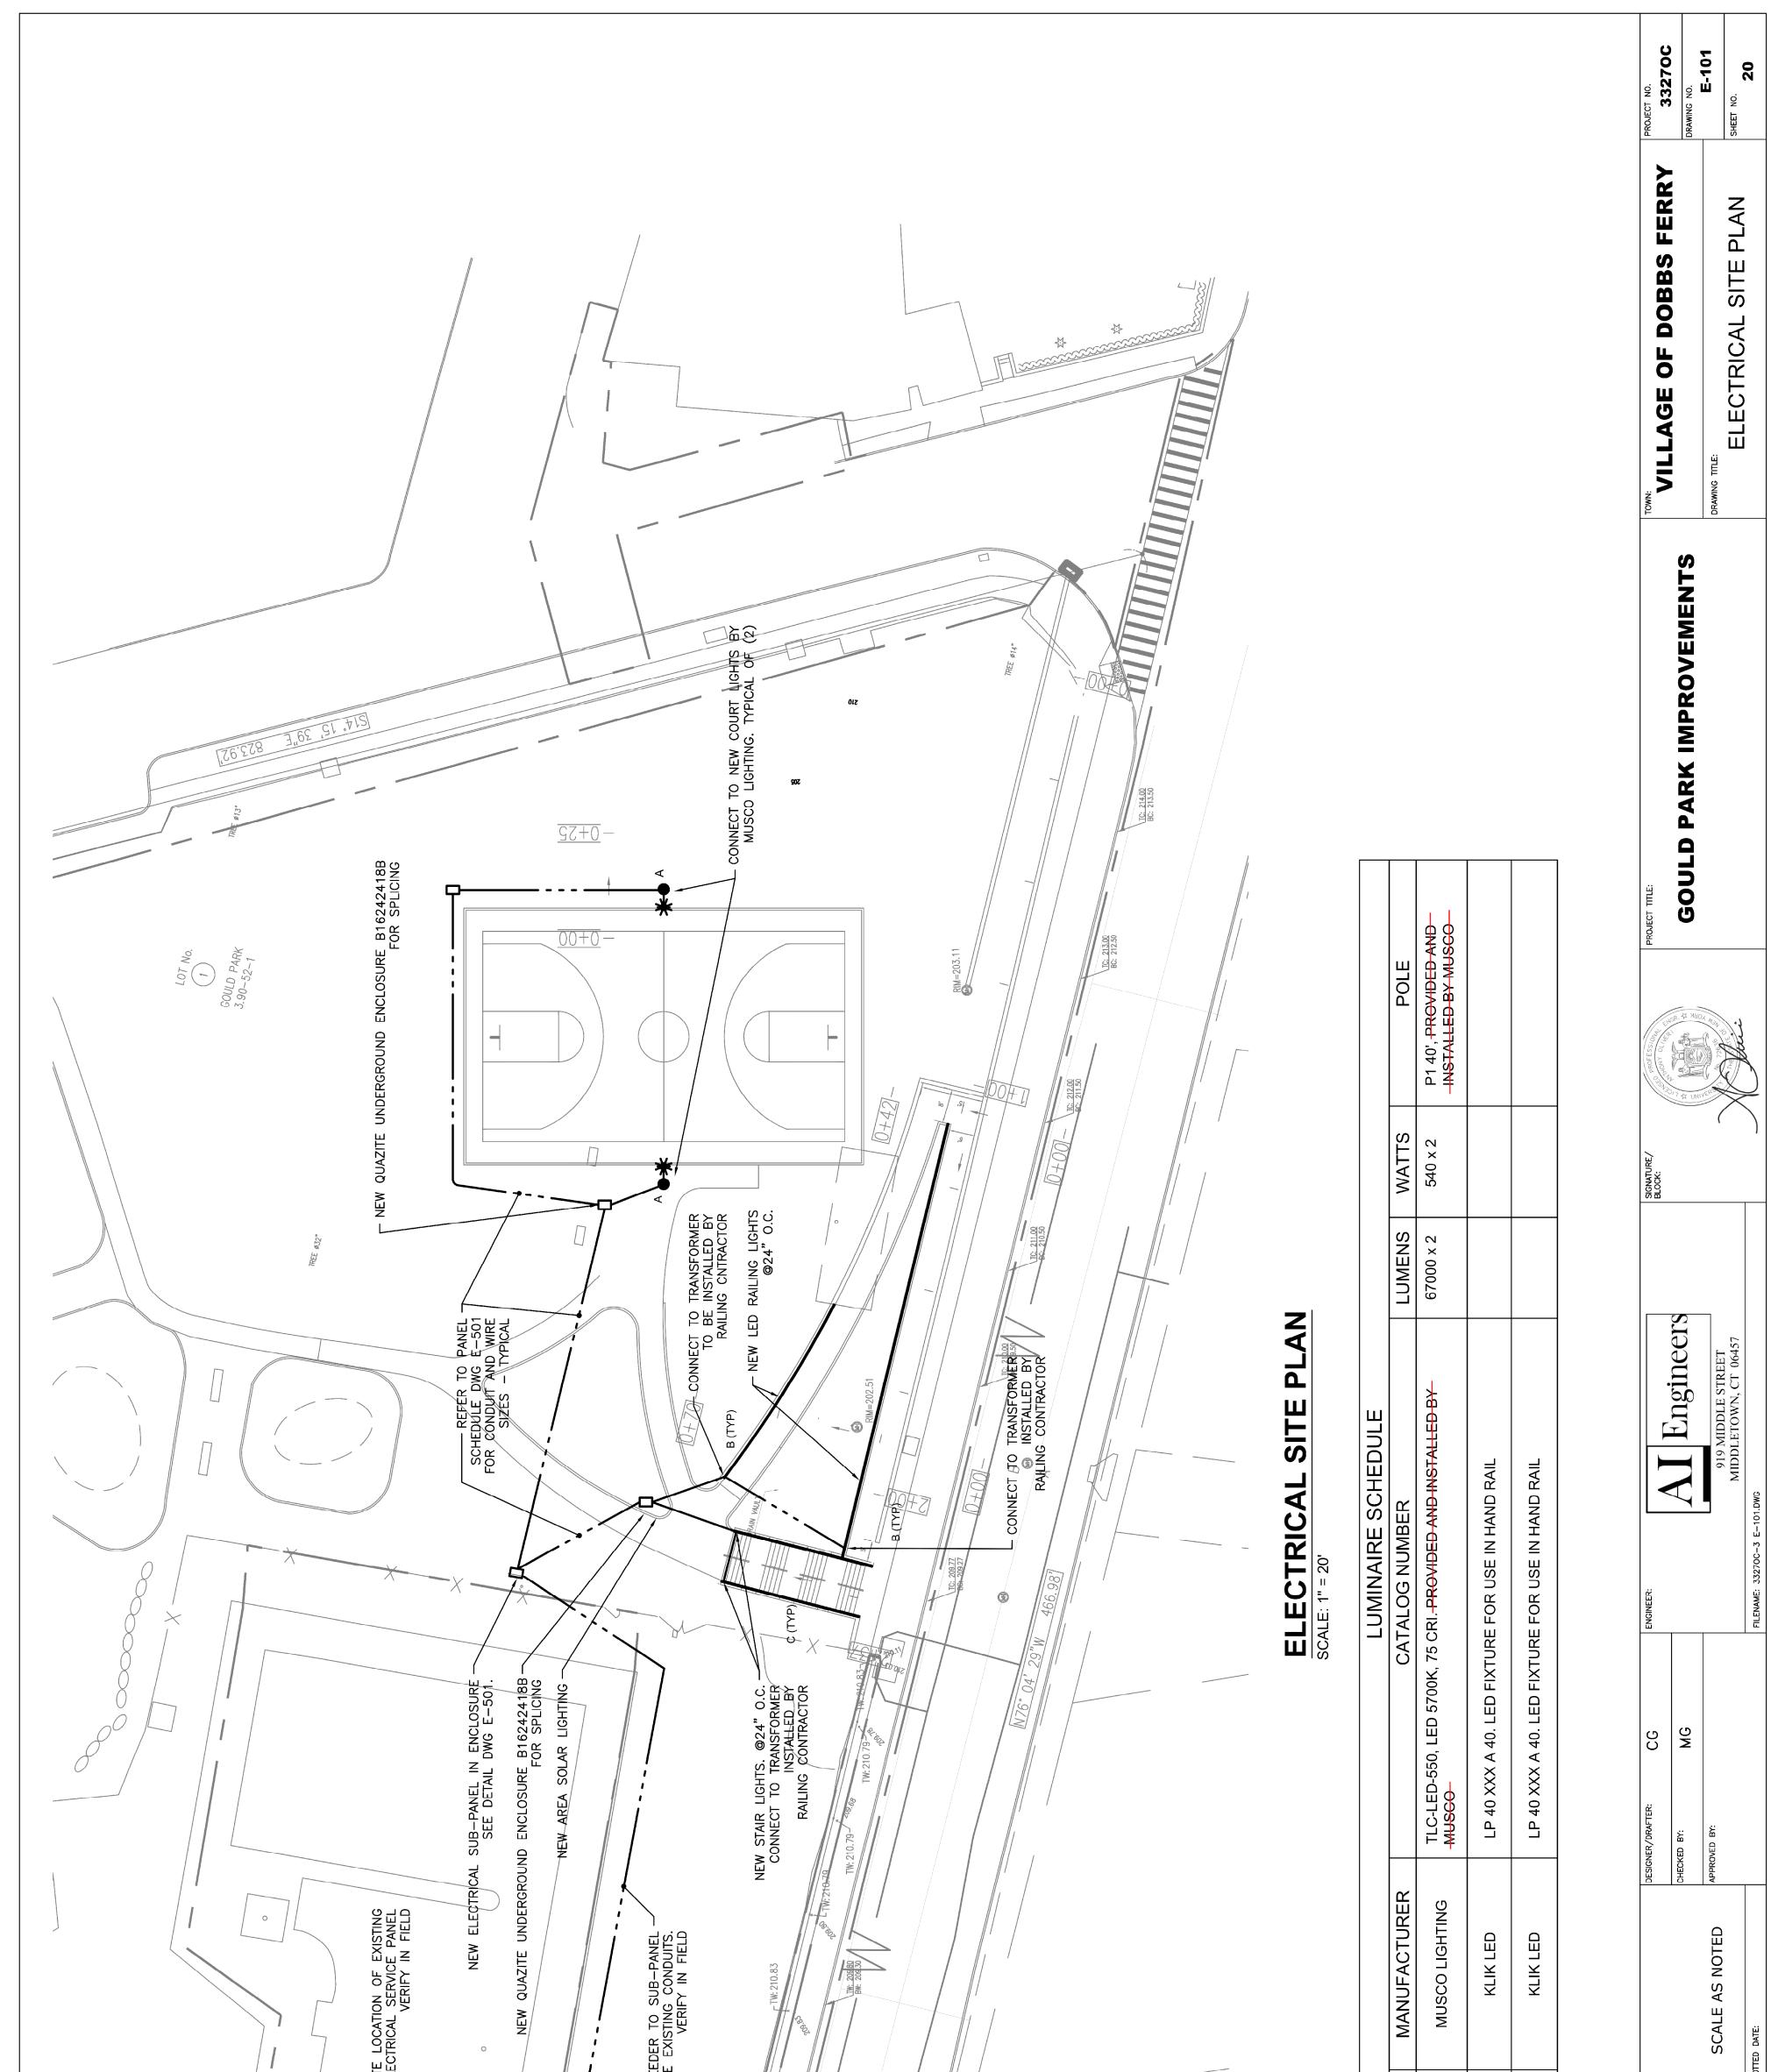

Source of the second se	RAGE RY RACIO BY RACIO B	SIGNATURE/ BLOCK: BLOCK:
	Multiple Step PMEL, IN FOLCIORH SEE EDIAL MECCONF. FOR COULE BRE 5-901 Sets and the E-901 Sets and the	WTER: CG ENGINEER: MG MG MG 919 MIDLE STREET MIDLETOWN, CT 06457 FILENAME: 33270C-3 E-101.DWG
o PPROXIMATE LOCATION OF EXISTING ELECTRICAL SERVICE PANEL VERIFY IN FIELD	NEW ELECTRICAL SUB NEW REPORT ON SUB-PANEL NEW FEEDER TO SUB-PANEL NEW ST NEW ST	DESIGNER/DF CHECKED BY SCALE AS NOTED O. PLOTED DATE:
MOS. 11, 51 LE 211'02.		ON THIS PLAN TO BE PAID FOR UNDER ITEM 900A
	\mathbf{L}	* ALL WORK DEPICTED (ALL WORK DEPICTED (REV. DATE